

Note :-
1. BUILDING WILL BE DESIGNED (STRUCTURES)
AS PER RELEVANT IS CODES FOR EARTH QUAKE
RESISTANCE.

PROJECT
REVISED (1ST REVISION) BUILDING PLANS OF
PHASE(V) PRIMA(WEST) FALLING UNDER
RESIDENTIAL COLONY
UNDER NEW INTEGRATED LICENSING POLICY(NIP)
DATED 11.05.2022 ON LAND MEASURING 116.28625
ACRES (LICENCE NO. 219 OF 2023 DATED 25-10-23)
(AN AREA MEASURING 103.05625 ACRES MIGRATION
FROM LICENCE NO. 27 OF 2012 DATED 02.04.2012
AND 13.24 ACRES AS FRESH AS FRESH APPLIED AREA)
IN SECTOR -76 & 77, GURUGRAM (NARASAR URBAN
COMPLEX BEING DEVELOPED BY DLF LTD IN
COLLABORATION WITH LAND OWNERS AND
ITS ASSOCIATE COMPANIES

DESIGN ARCHITECT

ARCHITECTS-
DESIGN FORUM
INTERNATIONAL
Address : K-47, KALASH COLONY, NEW
DELHI - 48
Phone : 011-46556600, 46556601, FAX -
46556601
Website : www.designforuminternational.com

ASSOCIATE ARCHITECTS

RSM'S ARCHITECTS PVT. LTD.
69, Nara Nivas, Bhikroni Kunj,
(Behind D2), Vasant Kunj,
New Delhi-110070.
Tel.: 011-26898616, 26898617
www.rsm's-arch.com

This is a PROVISIONAL BUILDING PLAN
approved only for the purpose of getting
Objections from the ground plans.

TO BE RECALCULATED BY THE OFFICE
DRAWN BY: *[Signature]* DATE: 10/01/2025
CHECKED BY: *[Signature]* DATE: 10/01/2025
ARCHITECT'S SEAL & SIGNATURE
OWNER'S SEAL & SIGNATURE
AUTOMATED SIGNATURE


JAN-2025 Scale: 1:600
Drawing Title: SITE PLAN
ST-02a
Drawing No: 03/01/2025

EXTERNAL FIRE LEGEND :-
EXTERNAL FIRE HYDRANT PIPE
EXTERNAL FIRE HYDRANT
EXTERNAL FIRE HOSE CABINET

WATER SUPPLY LEGEND :-
IRRIGATION WATER SUPPLY LINE
DOMESTIC WATER SUPPLY LINE
FLOODING WATER SUPPLY LINE
EXTERNAL GARDEN HYDRANT

SEWER LEGEND :-
GREEN LEVEL
INVERT LEVEL
CONNECTING LEVEL
ROAD LEVEL
FLOOR GROUND LEVEL
SMH - FLOOR GROUND LEVEL
GULLY TRAP
SEWER MANHOLE
SEWER MANHOLE

STORM WATER LEGEND :-
GREEN LEVEL
INVERT LEVEL
FLOOR GROUND LEVEL
CATCH BASIN
STORM WATER CATCH BASIN
STORM WATER MANHOLE
RAMP-CUT-01 200x200MM RAIN
WATER CUT-OUT
STORM WATER PIPE
HP - HARVESTING PIT
DC - DESILTING CHAMBER

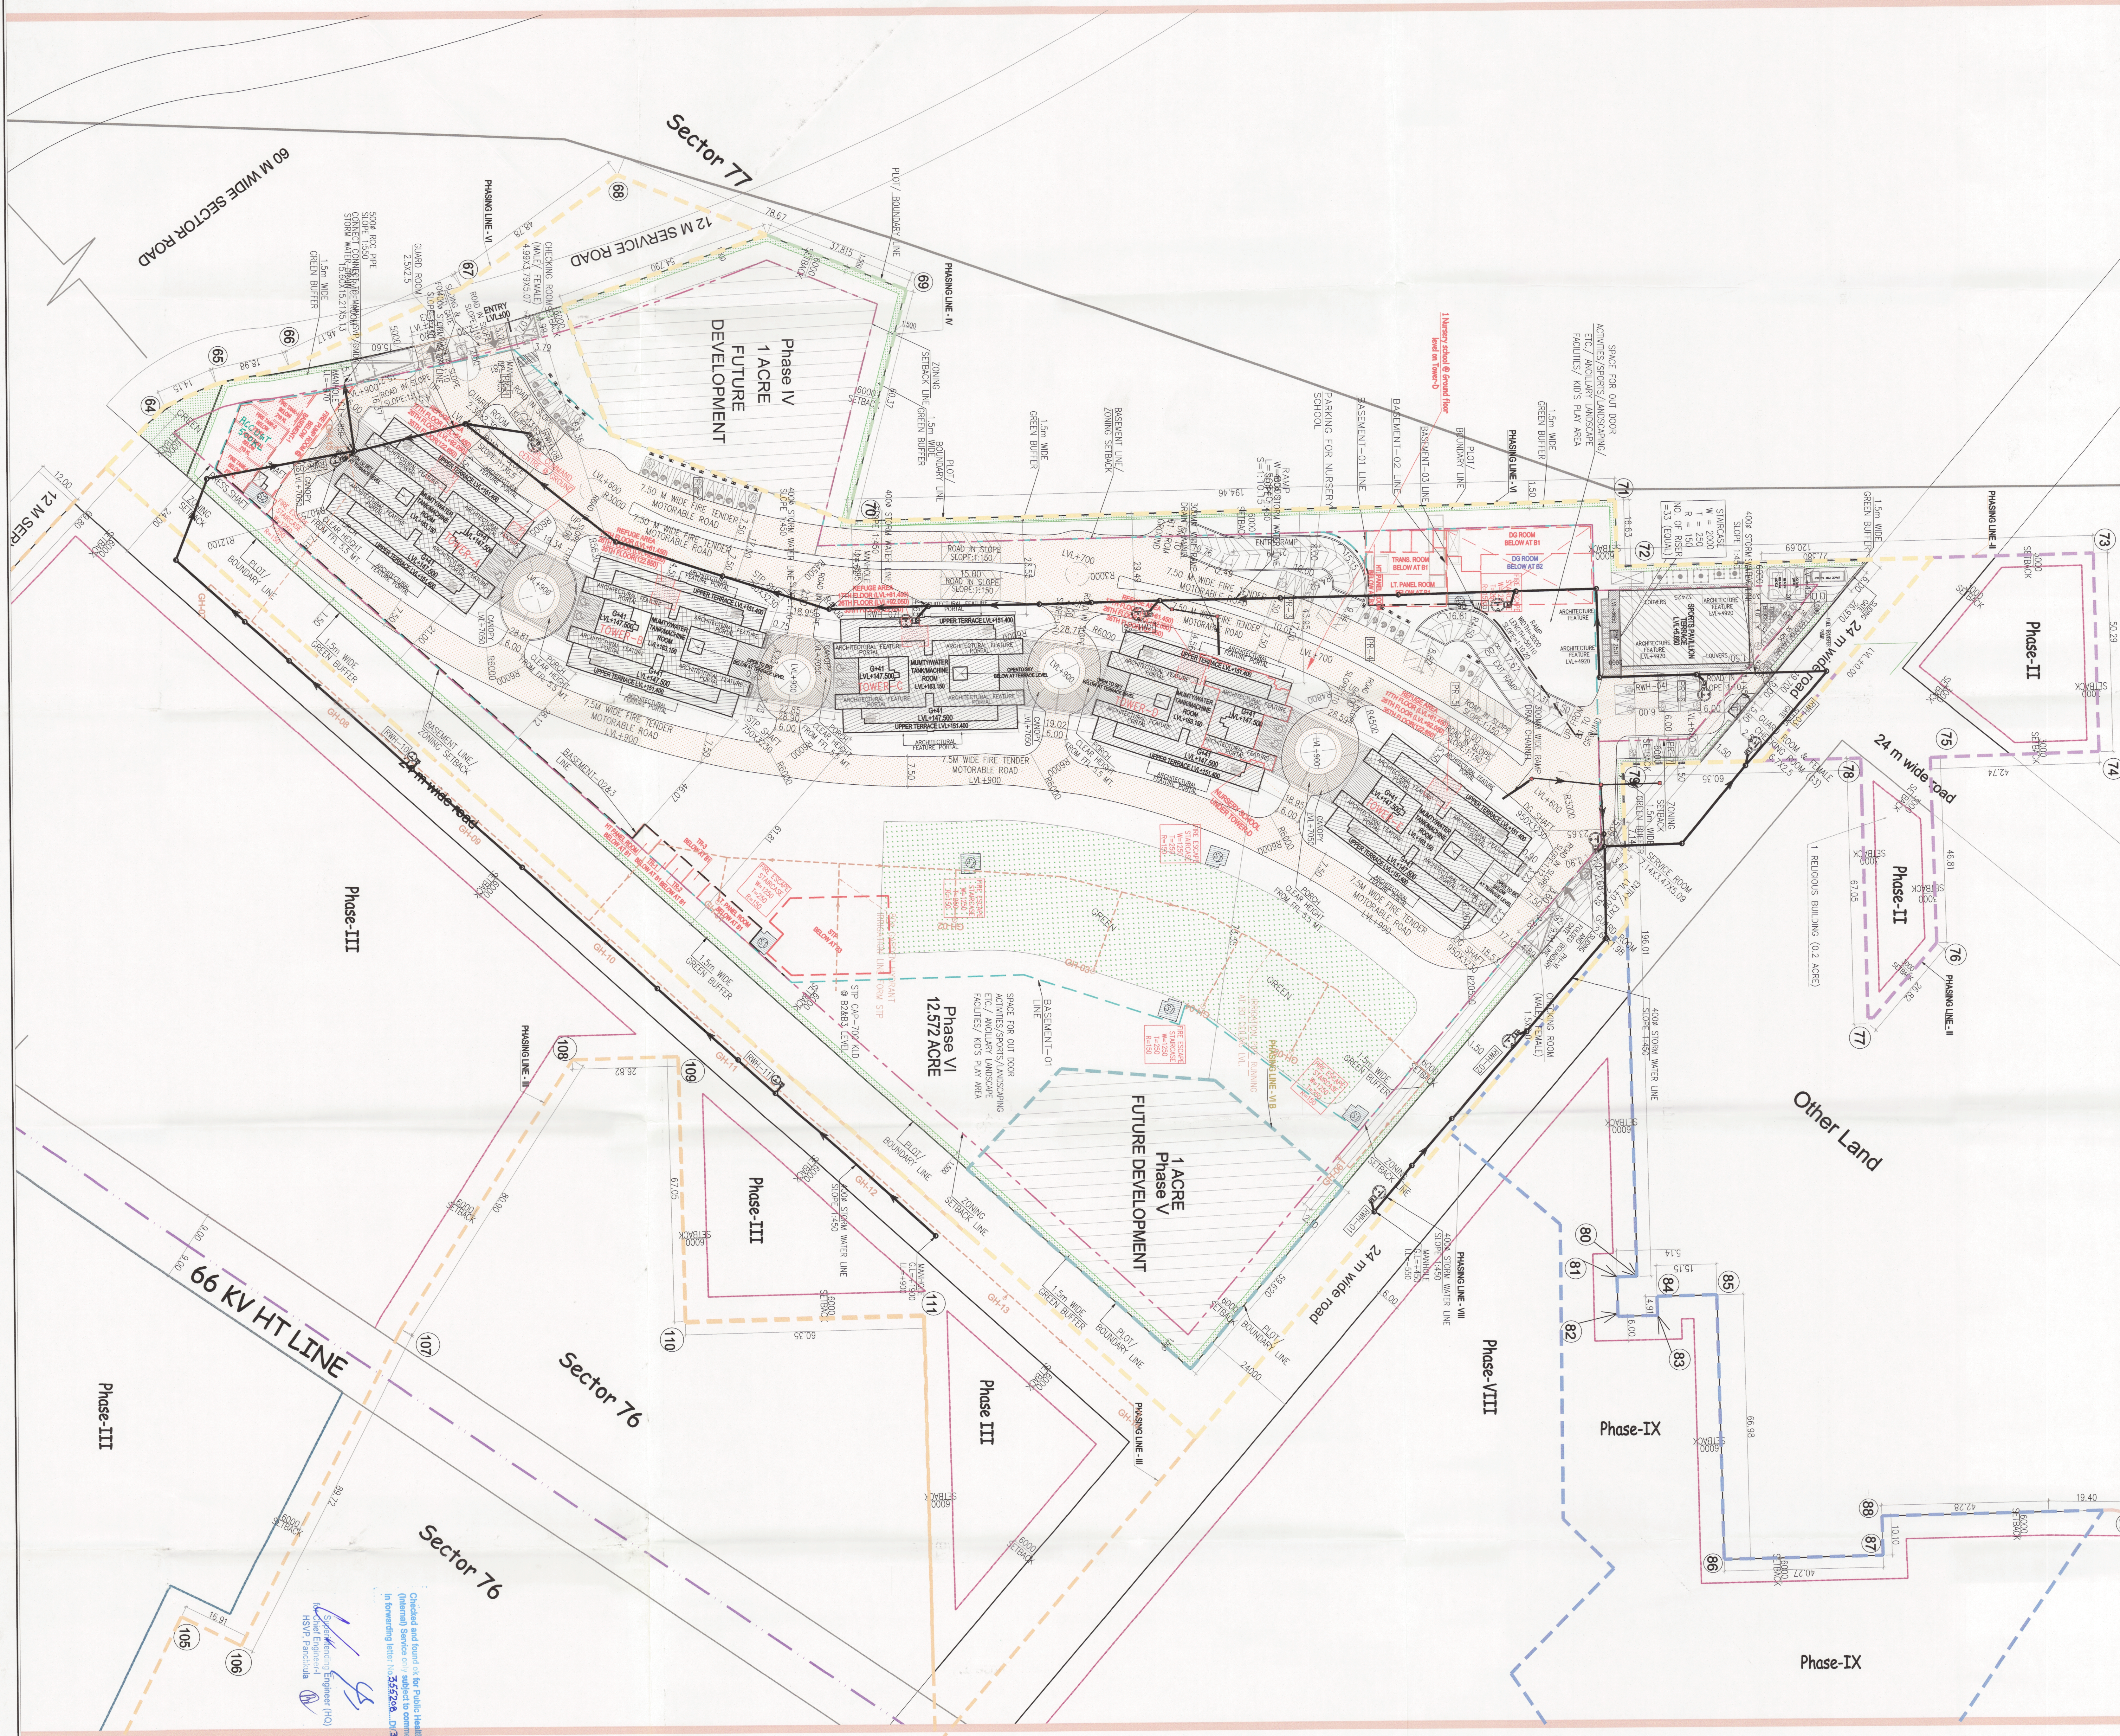

Checked and found ok for Public Health (PH) (Internal) Services of 1:500 scale, dated 10/01/2025
In forwarding letter: 10/01/2025, dated 10/01/2025
Signature of Engineer (PH)
HSP/PH/2025