

1. BUILDING WILL BE DESIGNED (STRUCTURES)
AS PER RELEVANT IS CODES FOR EARTH QUAKE
RESISTANCE.

SHEET NO.	APPROVAL	DESCRIPTION
60	EMP	1500 RAIN WATER PIPE
61	EMP	250 RAIN WATER PIPE
62	SP	1000 SOIL & WASTE PIPE
63	SP	1000 VENT PIPE
64	DWS	DOMESTIC WATER SUPPLY ON LAKE PIPE
65	DWS	DOMESTIC WATER SUPPLY ON LAKE PIPE TO TOP 2 FLOOR
66	DWS	DOMESTIC WATER SUPPLY ON LAKE PIPE TO PH. FLOOR
67	DWS	FLOODING WATER SUPPLY ON LAKE PIPE
68	DWS/DWS	DOMESTIC WATER SUPPLY TO OFF. FLOOR
69	FWS (P)	FLOODING WATER SUPPLY TO OFF. FLOOR
70	FWS (P)	1500 M/S PARKING DRAIN PIPE
X		1500 M/S RAMM DRAIN PIPE

DOOR AND WINDOW SCHEDULE					
SR NO	TYPE	WIDTH (mm)	HEIGHT (mm)	SILLAGE	UNIT/VALUE
1	01	750	2100	0	21000
2	02	750	2100	0	21000
3	03	750	2100	0	21000
4	04	600	2100	0	21000
5	05	600	2100	0	21000
6	06	600	2100	0	21000
7	07	1050	2100	0	21000
8	08	1050	2100	0	21000
9	09	1050	2100	0	21000
10	10	1050	2100	0	21000
11	11	1050	2100	0	21000
12	01	1050	2100	0	21000
13	02	1050	2100	0	21000
14	03	1050	2100	0	21000
15	04	1050	2100	0	21000
16	05	1050	2100	0	21000
17	06	1050	2100	0	21000
18	07	1050	2100	0	21000
19	08	1050	2100	0	21000
20	09	1050	2100	0	21000
21	10	1050	2100	0	21000
22	01	1050	2100	0	21000
23	02	1050	2100	0	21000
24	03	1050	2100	0	21000
25	04	1050	2100	0	21000
26	05	1050	2100	0	21000
27	06	1050	2100	0	21000
28	07	1050	2100	0	21000
29	08	1050	2100	0	21000
30	09	1050	2100	0	21000
31	10	1050	2100	0	21000
32	01	1050	2100	0	21000
33	02	1050	2100	0	21000
34	03	1050	2100	0	21000
35	04	1050	2100	0	21000
36	05	1050	2100	0	21000
37	06	1050	2100	0	21000
38	07	1050	2100	0	21000
39	08	1050	2100	0	21000
40	09	1050	2100	0	21000
41	10	1050	2100	0	21000
42	01	1050	2100	0	21000
43	02	1050	2100	0	21000
44	03	1050	2100	0	21000



REVISED (TIL REVISION) BUILDING PLANS OF
PHASE-IV (PRIVANA-WEST) FALLING UNDER
RESIDENTIAL COLONY
UNDER NEW INTEGRATED LICENSING POLICY (NILP)
DATED 11.05.2022 ON LAND MEASURING - 16.29625
ACRES (LICENSE NO. 219 OF 2022 DATED 25-10-23)
(AN AREA MEASURING 0.03.06625 ACRES MIGRATION
FROM LICENSE NO. 21 OF 2017 DATED 02.04.2012
AND 13.24 ACRES AS FRESH AS FRESH APPLIED AREA)
IN SECTOR - 78 & 77, GURUGRAM MANES (URBAN
COMPLEX BEING DEVELOPED BY DLF LTD IN
COLLABORATION WITH LAND OWNERS AND
S ASSOCIATE COMPANIES

ARCHITECTS:-
DESIGN FORUM
INTERNATIONAL

Address: K-47, KAILASH COLONY, NEW
DELHI-48
Phone : 011-46556600, 46556601, FAX -
46556601
Website: www.designforuminternational.com

RES|N|S
ARCHITECTS

RSMS ARCHITECTS PVT. LTD.
69, Nora Niwas Bhawani Kunj
(Behind D2), Vasant Kunj,
New Delhi-110070.
Tel.: 011-26898616, 26898617
www.rsms-arch.com

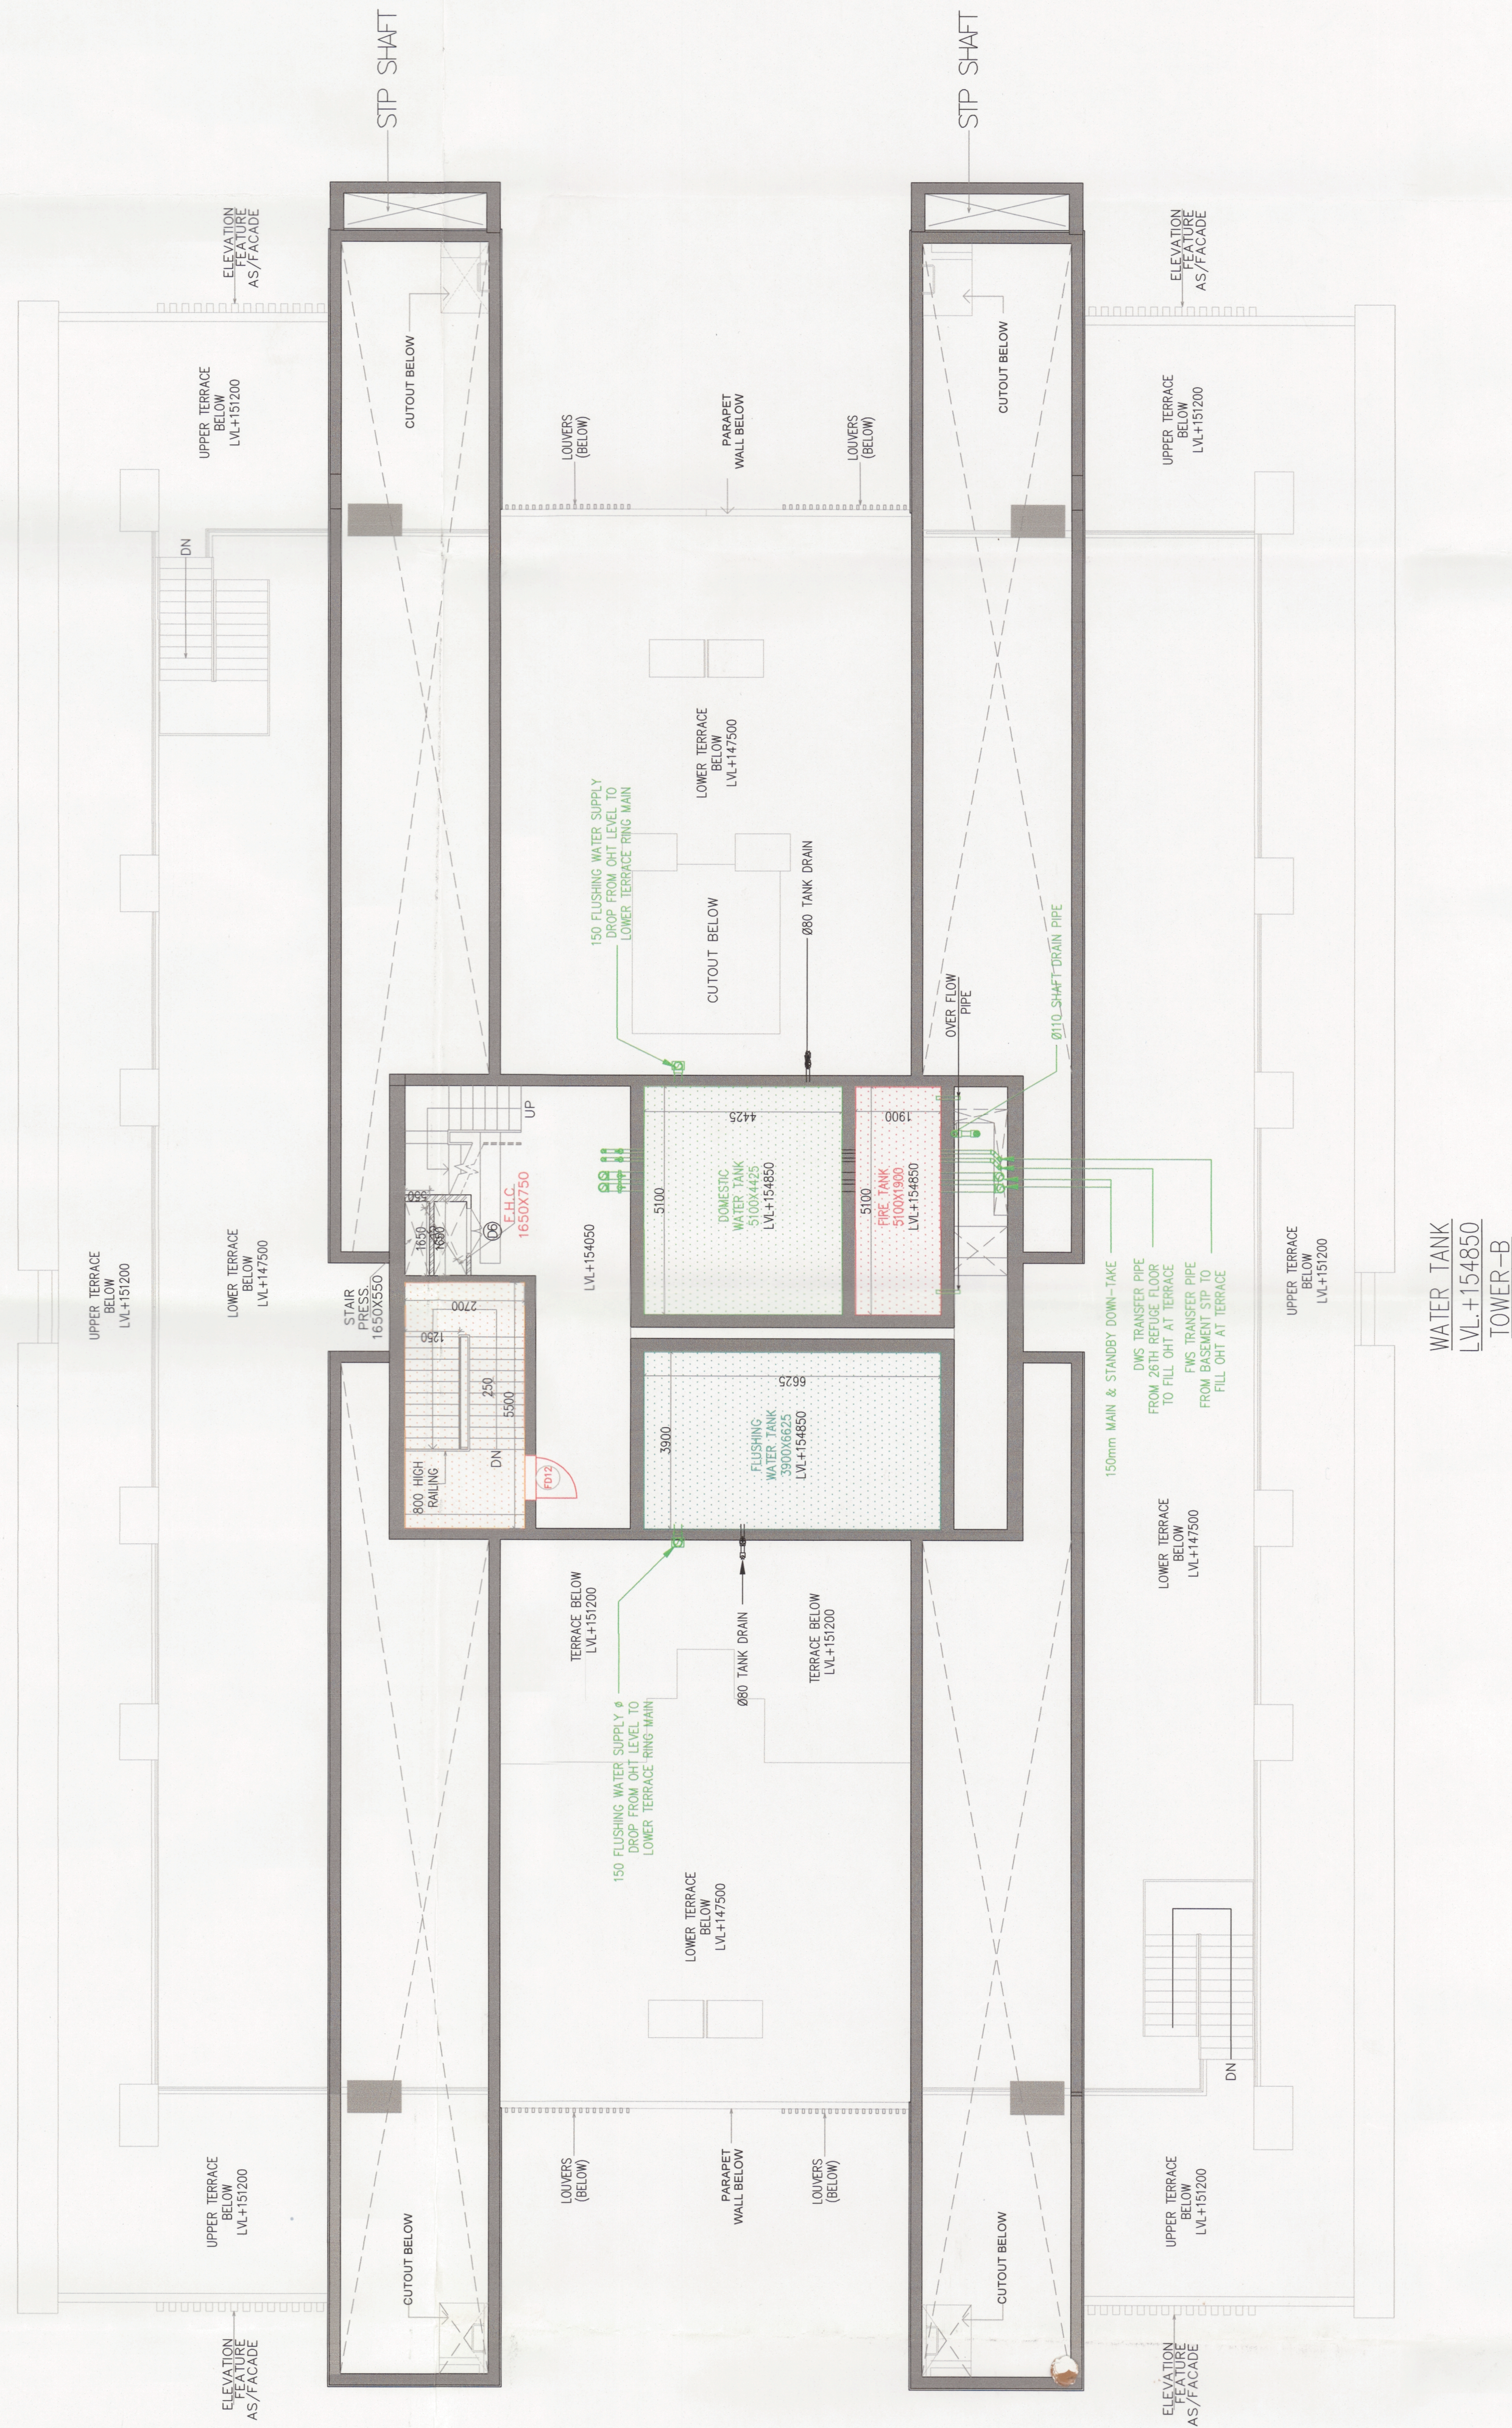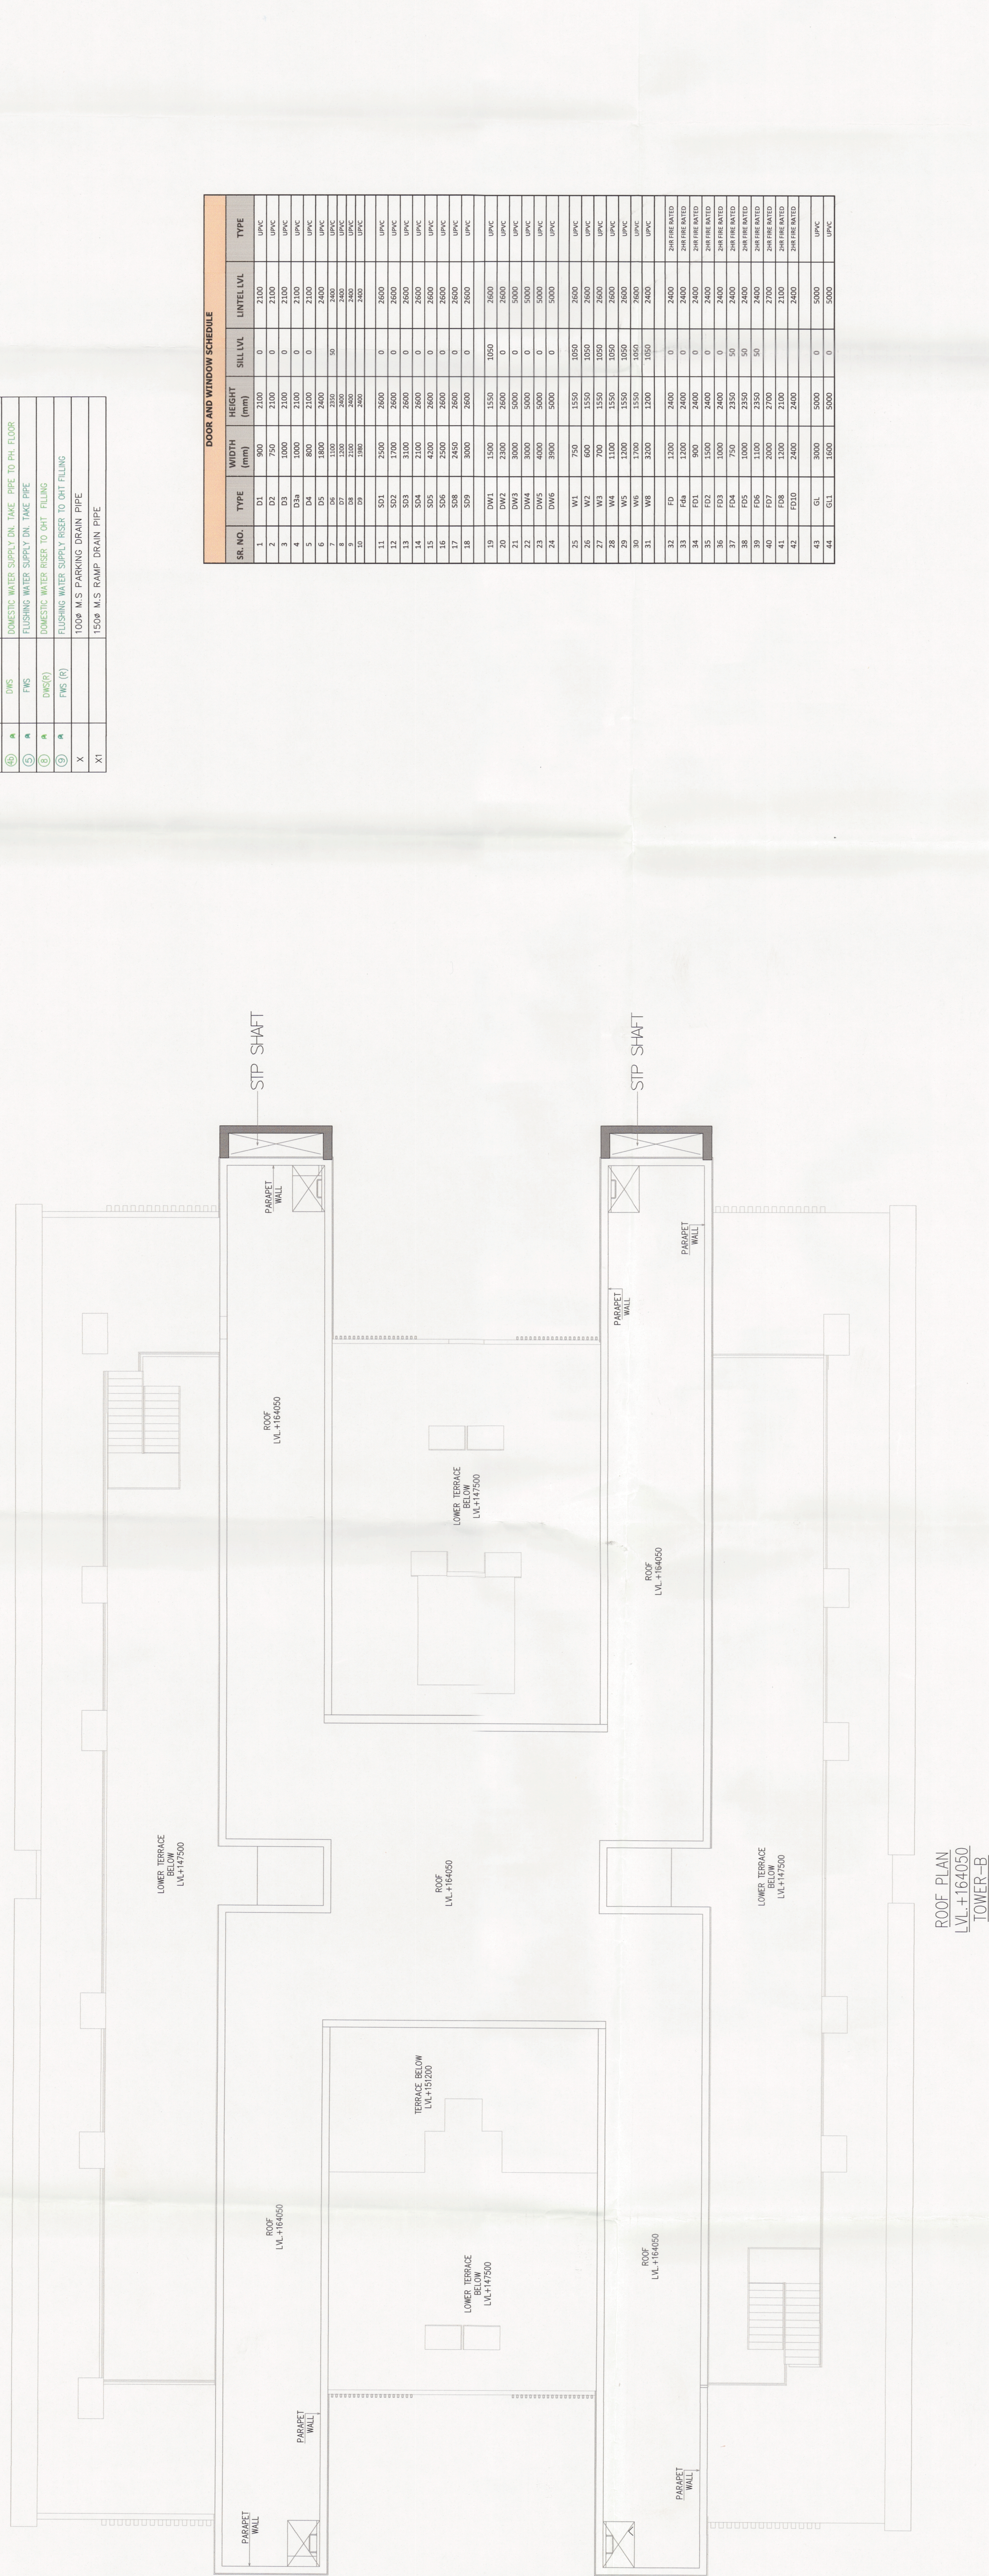

This is a "PROVISIONAL BUILDING PLAN"
approved only for the purpose of inviting
bids from the general public

Ullmann
S.T.P. (HQ)
Member Secretary
B.P.A.C.

Q ATP(HQ)

Checked and found ok for Public Health
(Internal) Service only subject to comments in
in forwarding letter No. 3552.08.....DVS/12/12/12

JDH(MC)
Member
BPAC

Superintending Engineer (HQ)

PROJECT'S SEAL


CHANCHAL JAIN
(REGISTERED ARCHITECT)
12/05/2071

Scale : 1:100

																													
---	--	---	---	---	---	---	---	---	---	---	---	---	---	---	---	---	---	---	---	---	---	---	---	---	---	---	---	---	---

WATER TANK & ROOF PLAN

05/01/2025