


DRG NO. SS-P-108

KEY PLAN

F.O. (Hd)
DPS PCL
Member B.P.C.

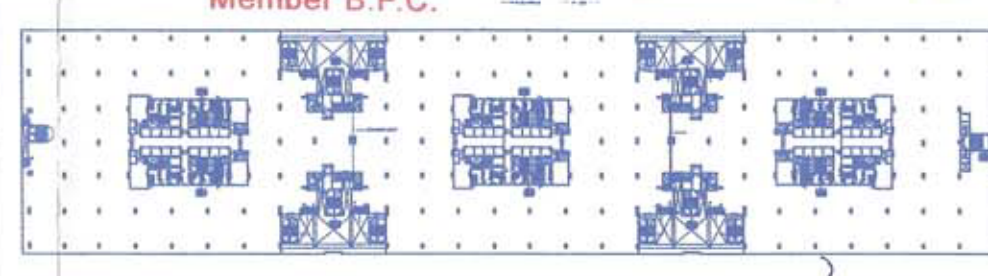

BLOCK-A BLOCK-B BLOCK-C
(BALWANT SINGH) S.D.

NOTES

- This development have been conceived, designed and drafted on basis of the following parameters:
- All toilets will be mechanically ventilated. Conditioned air from the office floor will be sucked in to the toilets and vented out through a vent shaft.
 - Basement will be artificially ventilated.
 - All spaces (parking basement, service basement etc.) will be artificially lit. Any natural light which is available in the office spaces is only incidental and not essential to the functioning of the buildings.
 - 100% standby generating capacity will be provided for the entire electrical requirement of the total scheme. This therefore includes standby generation for all common services, fire services, lifts etc. and also the entire electrical load for ventilation & air-conditioning lights and all office equipment.
 - This building will be sprinkled as per NBC norms.
 - partition/ modifications for interior space/ layout and toilet block addition and alteration shall be as per client request/ requirements of usable area of floor plate

DOOR SCHEDULE

TYPE	OPENING	CLL	LEVEL	REMARKS
D1	750x2100	#0.0	+2100	INTERNAL TOILET DOOR (SINGLE LEAF)
D2	1000x2100	#0.0	+2100	INTERNAL TOILET DOOR (SINGLE LEAF)
D3	1000x2100	#0.0	+2100	HANDICAPPED TOILET (SINGLE LEAF)
D4	1300x2100	#0.0	+2100	LIFT LOBBY DOOR (SINGLE LEAF)
D5	1300x2100	#0.0	+2100	AHU ROOM (2BRS FIRE RATED) (SINGLE LEAF)
D6	2000x2400	#0.0	+2400	SHUTTLE LIFT LOBBY (DOUBLE LEAF) (2BRS FIRE RATED)
D7	2000x2100	#0.0	+2100	OFFICE MAIN DOOR (DOUBLE LEAF) (2BRS FIRE RATED)
D8	2400x3000	#0.0	+3000	GLASS DOOR ENTRANCE HALL/ATRIUM (DOUBLE LEAF)
FD	1700x2100	#0.0	+2100	GLASS DOOR ENTRANCE HALL/ATRIUM (DOUBLE LEAF)
FD1	1200x2100	#0.0	+2100	GLASS DOOR ENTRANCE HALL/ATRIUM (DOUBLE LEAF)
FD2	1000x1800	#0.0	+2100	GLASS DOOR ENTRANCE HALL/ATRIUM (DOUBLE LEAF)
FD3	1000x2100	#0.0	+2100	GLASS DOOR ENTRANCE HALL/ATRIUM (DOUBLE LEAF)
BD1	1600x1200	1100	+2250	RY ROOM
BD2	1600x1200	1100	+2250	RY ROOM
BD3	1600x1200	1100	+2250	RY ROOM

Architect
Hafeez Contractor
29 Bank Street, Bombay 400 023, Tel:2661920

PROJECT:
REVISED BUILDING PLAN OF CYBER PARK COLONY AREA MEASURING 11.816 ACRES (LICENCE NO.180 OF 2007 DATED 02.05.2007) IN SECTOR -20, GURGAON MANESAR URBAN COMPLEX.


OWNER:
DLF M/S DLF CYBER CITY DEVELOPERS LTD.

CONSULTANT:-

DRG TITLE:-


TERRACE LVL PLAN

REVISION	JOB NO:-	DRG NO:-	NORTH:-
		SS-P-108	
	SCALE:-	DATE:-	
	1:250	21/08/2017	
FILE:-	DEALT BY:-	CHECKED BY:-	APPROVED BY:-
SIGNATURE & SEAL OF ARCHITECT:-		SIGNATURE & SEAL OF OWNER:-	

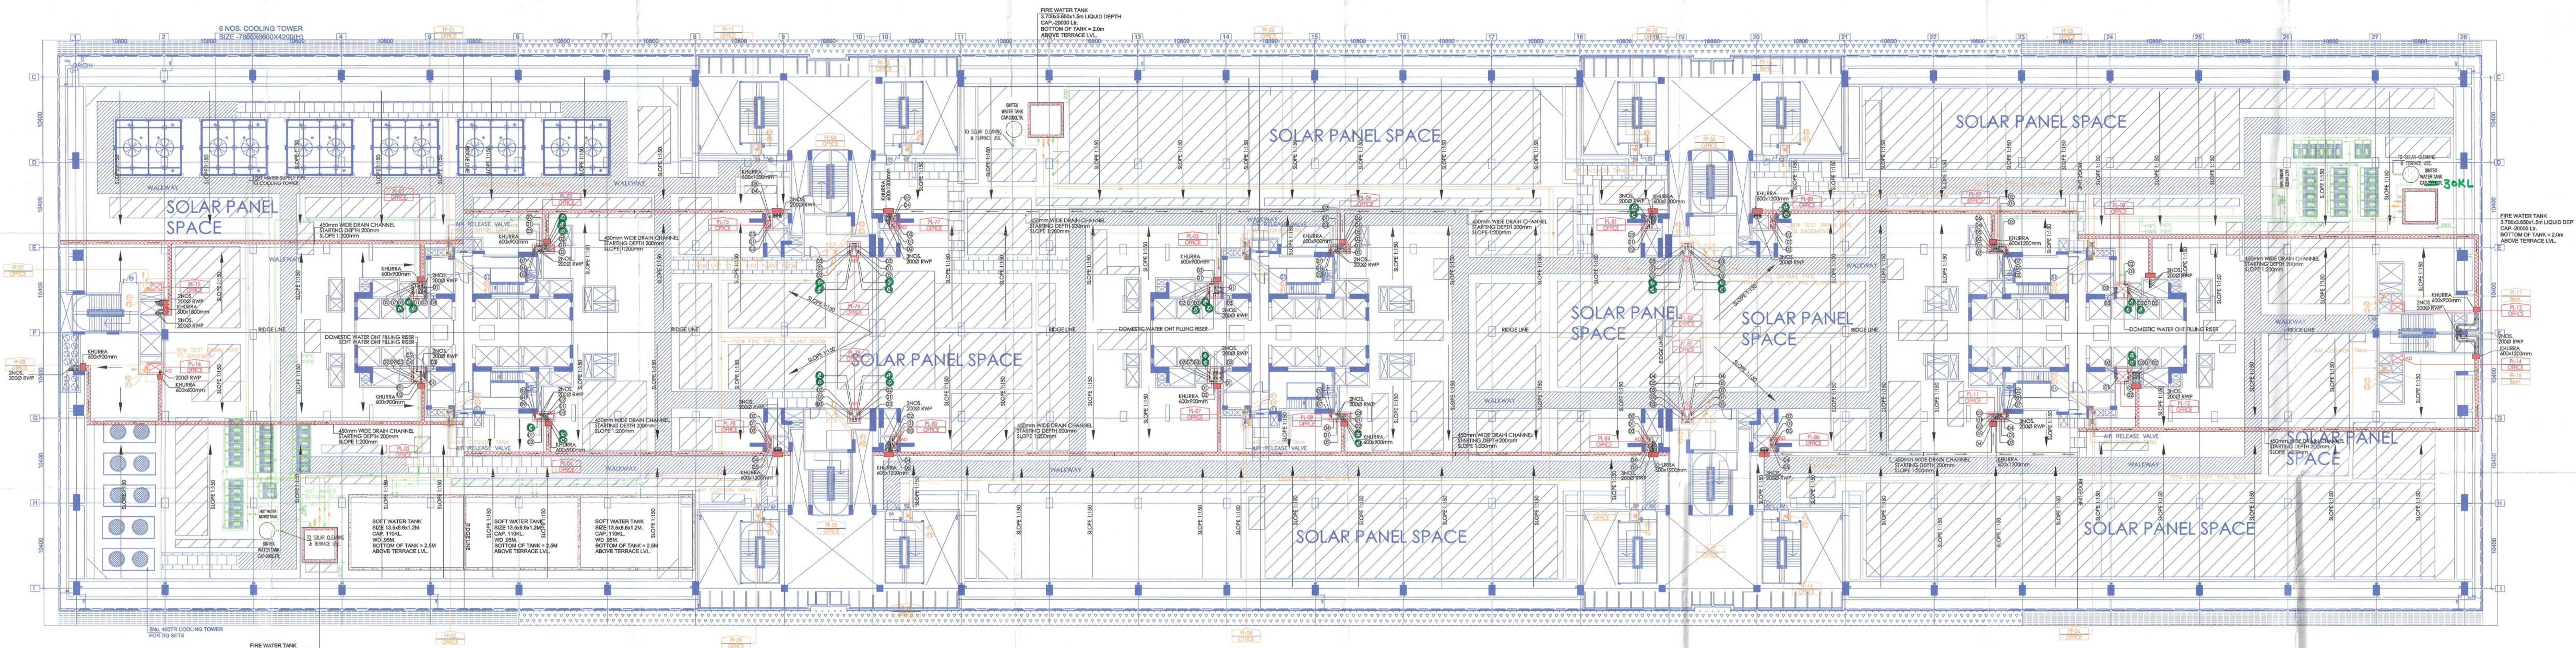


SOLAR PANEL SPACE


PLUMBING LEGEND:-
 (S) 1000 SOL PIPE
 (W) 1000 WASTE PIPE
 (V) 75mm Vent pipe (VP)
 (D) DWS DN TAKE
 (F) FWS DN TAKE
 (P) = SOL PIPE
 (D) = FLOOR DRAIN
 (R) = FLOOR RAMP
 (G) = FLOOR GRATING
 (T) = URINAL TRAP
 (A) = ACCESS DOOR
 (W) = DOMESTIC WATER SUPPLY
 (FWS) = FLUSHING WATER SUPPLY
 (HWS) = HOT WATER SUPPLY
 (F) = 1000 FIRE HYDRANT RISER PIPE
 (D) = 800 SPRINKLER DRAIN PIPE

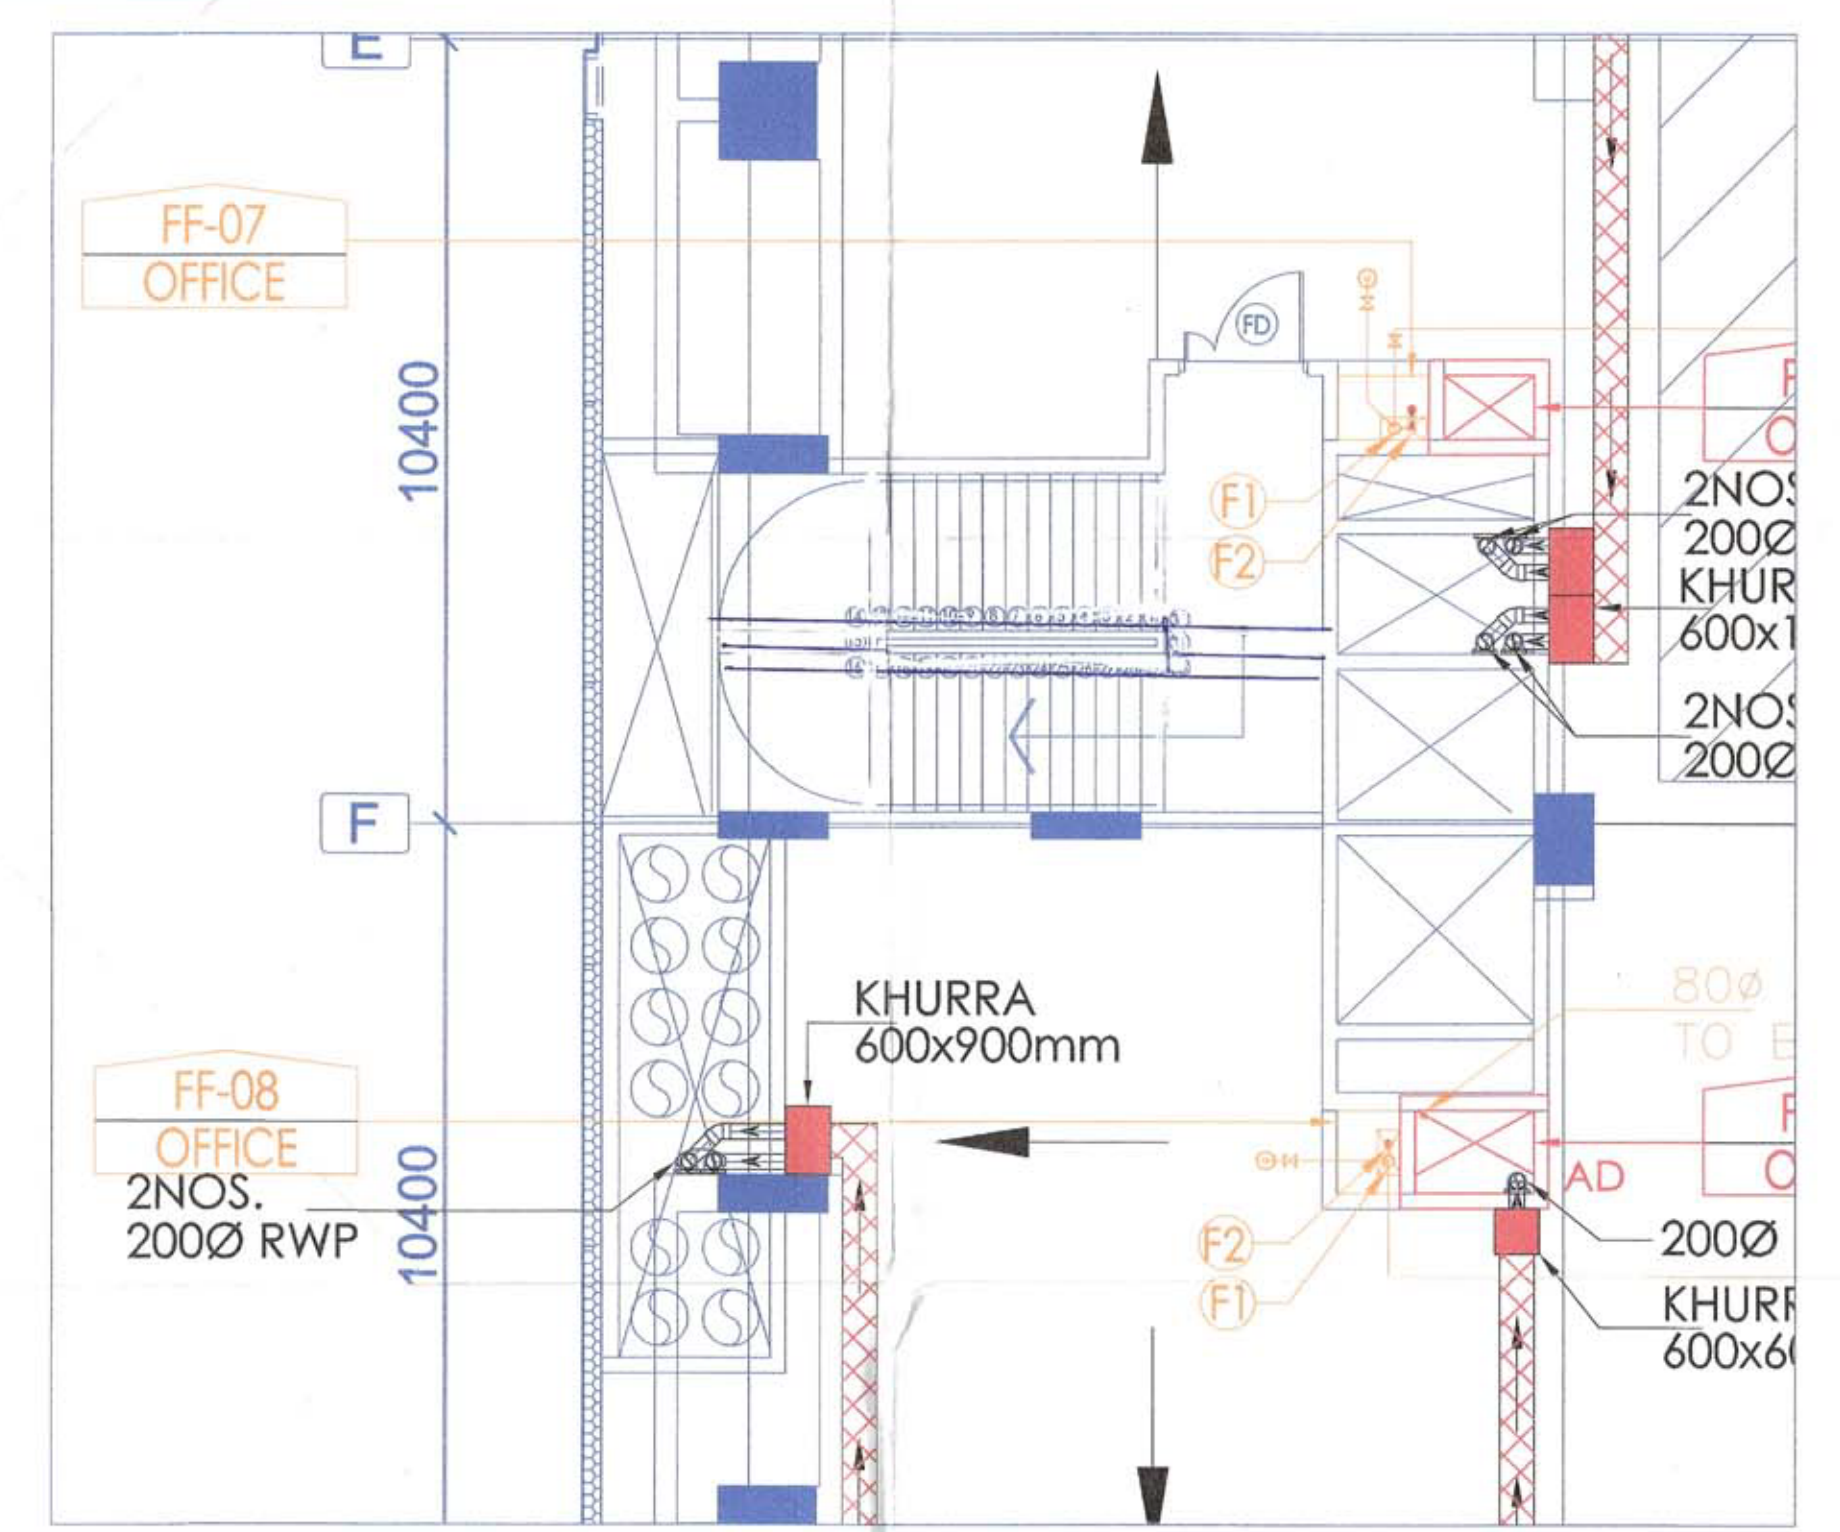


ENLARGEMENT DETAIL OF STAIRCASE CORE IN BLOCK-A

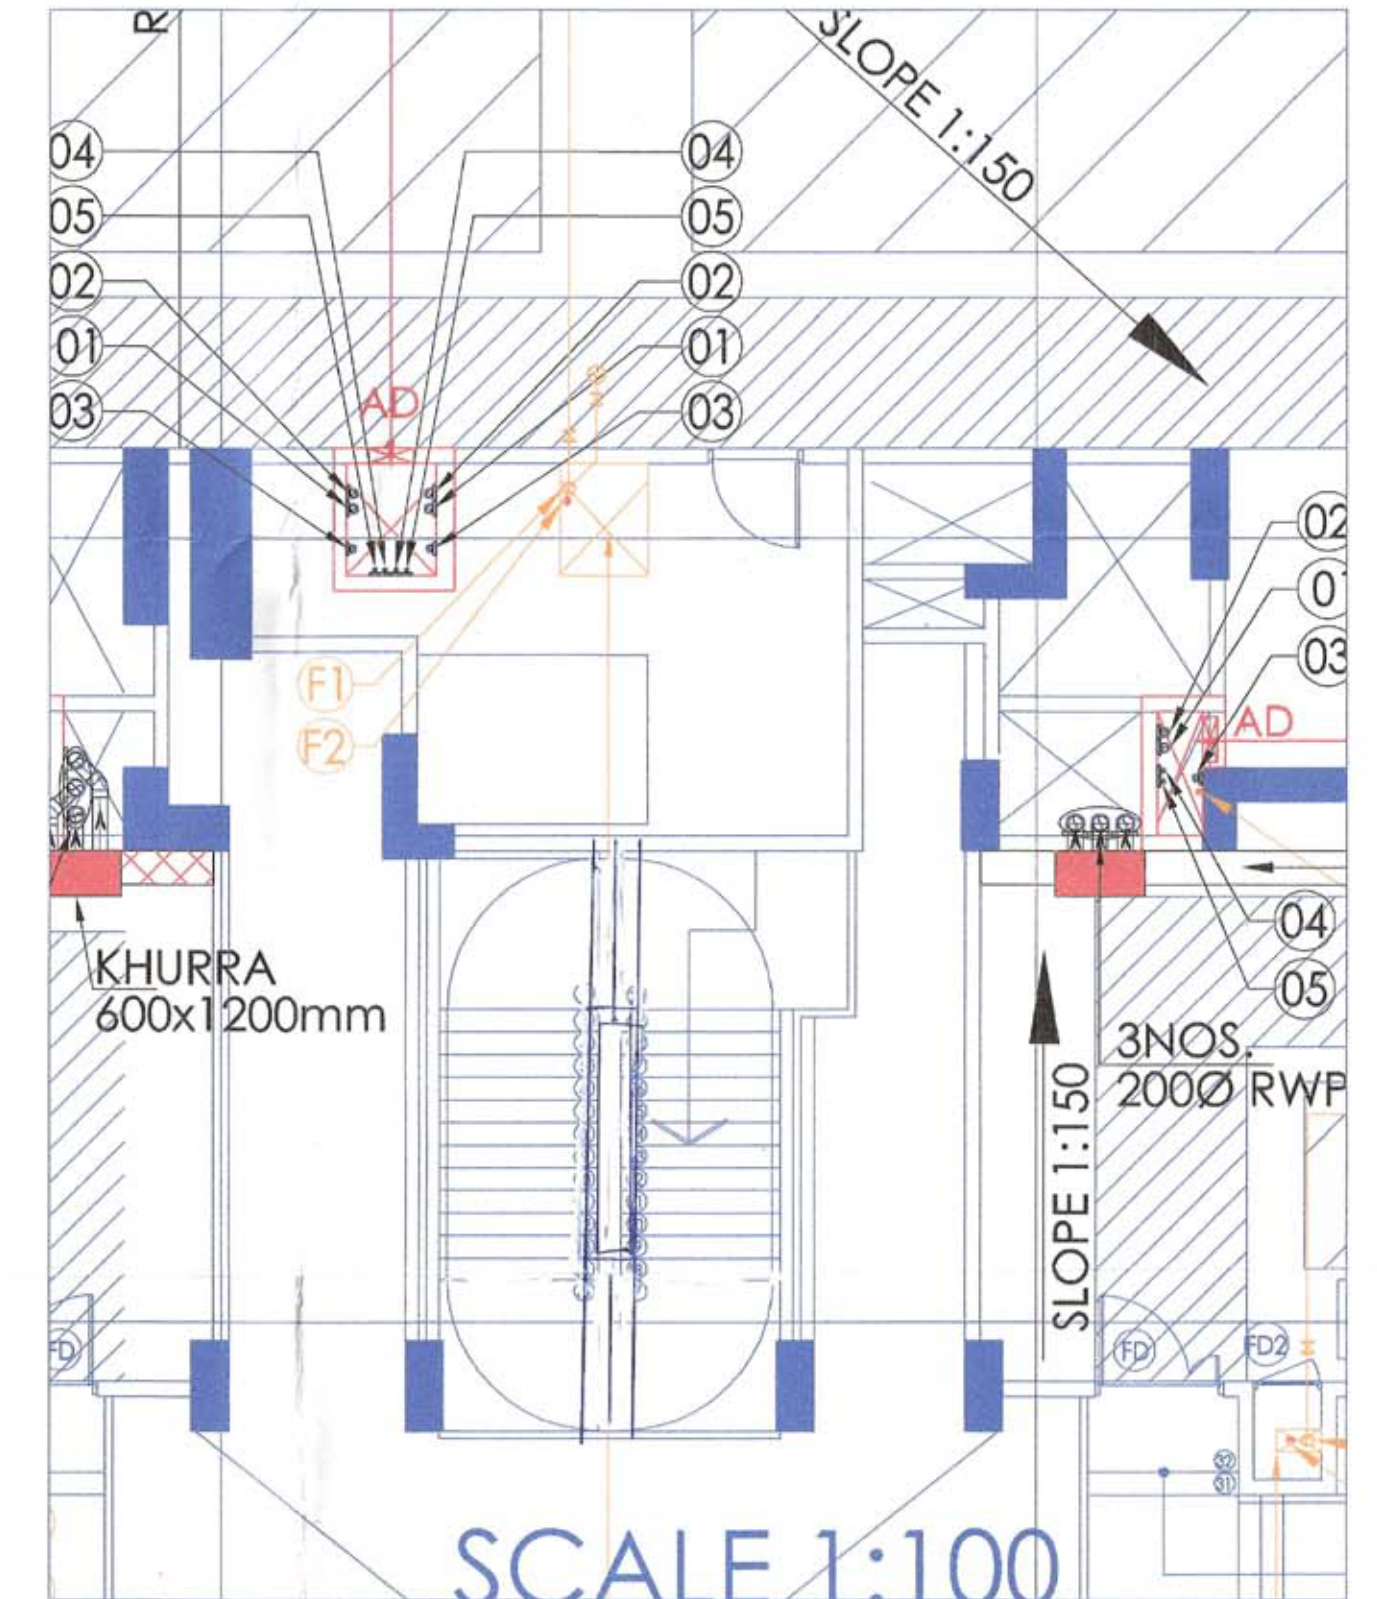

ENLARGEMENT DETAIL OF CORE BETWEEN BLOCK B&C

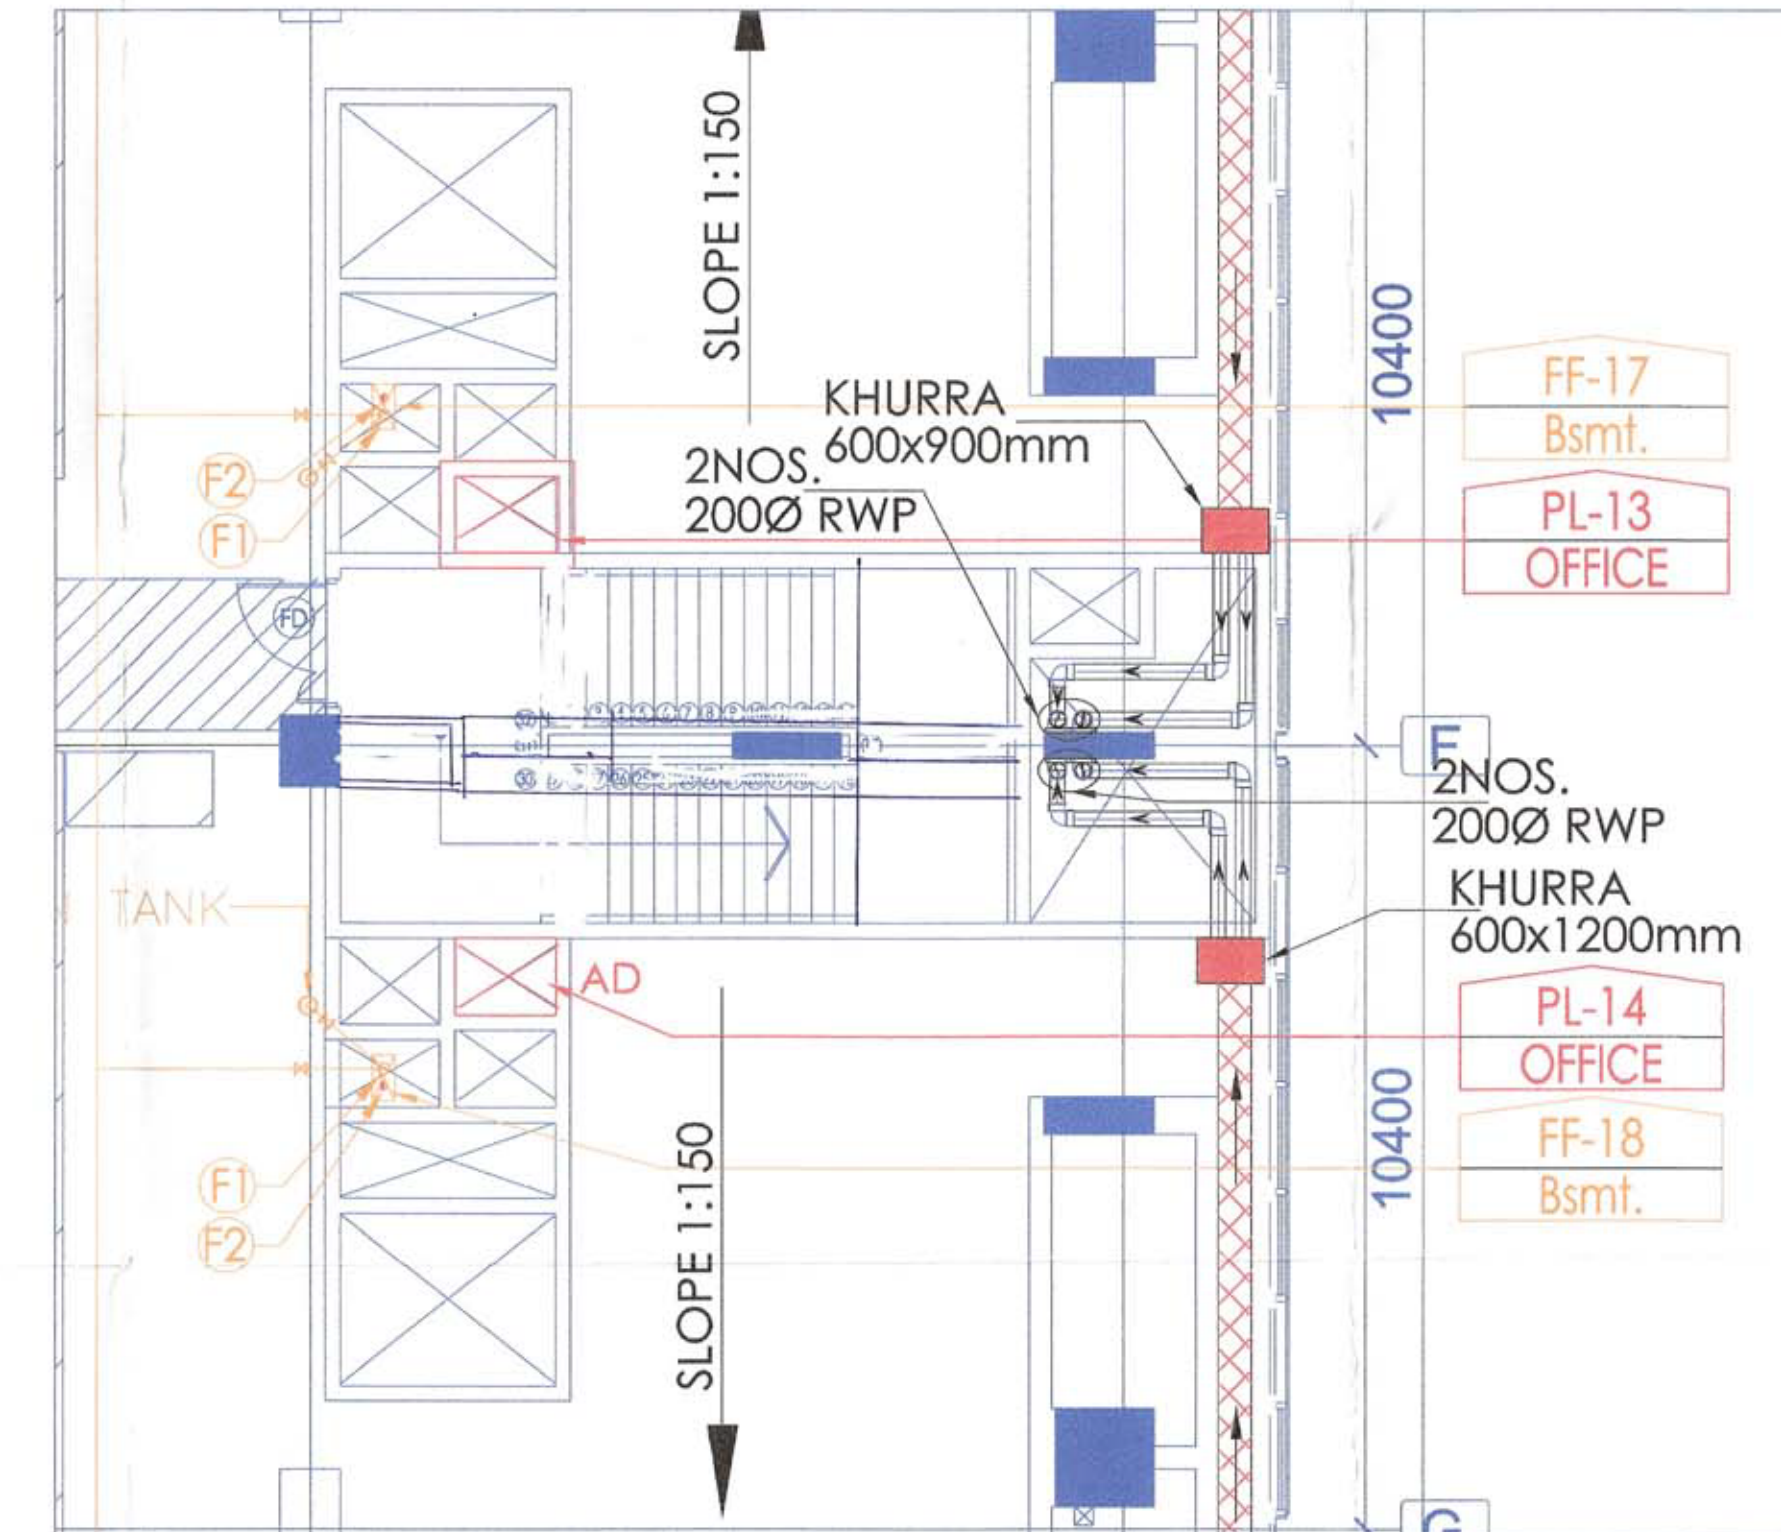

ENLARGEMENT DETAIL OF STAIRCASE CORE IN BLOCK-C

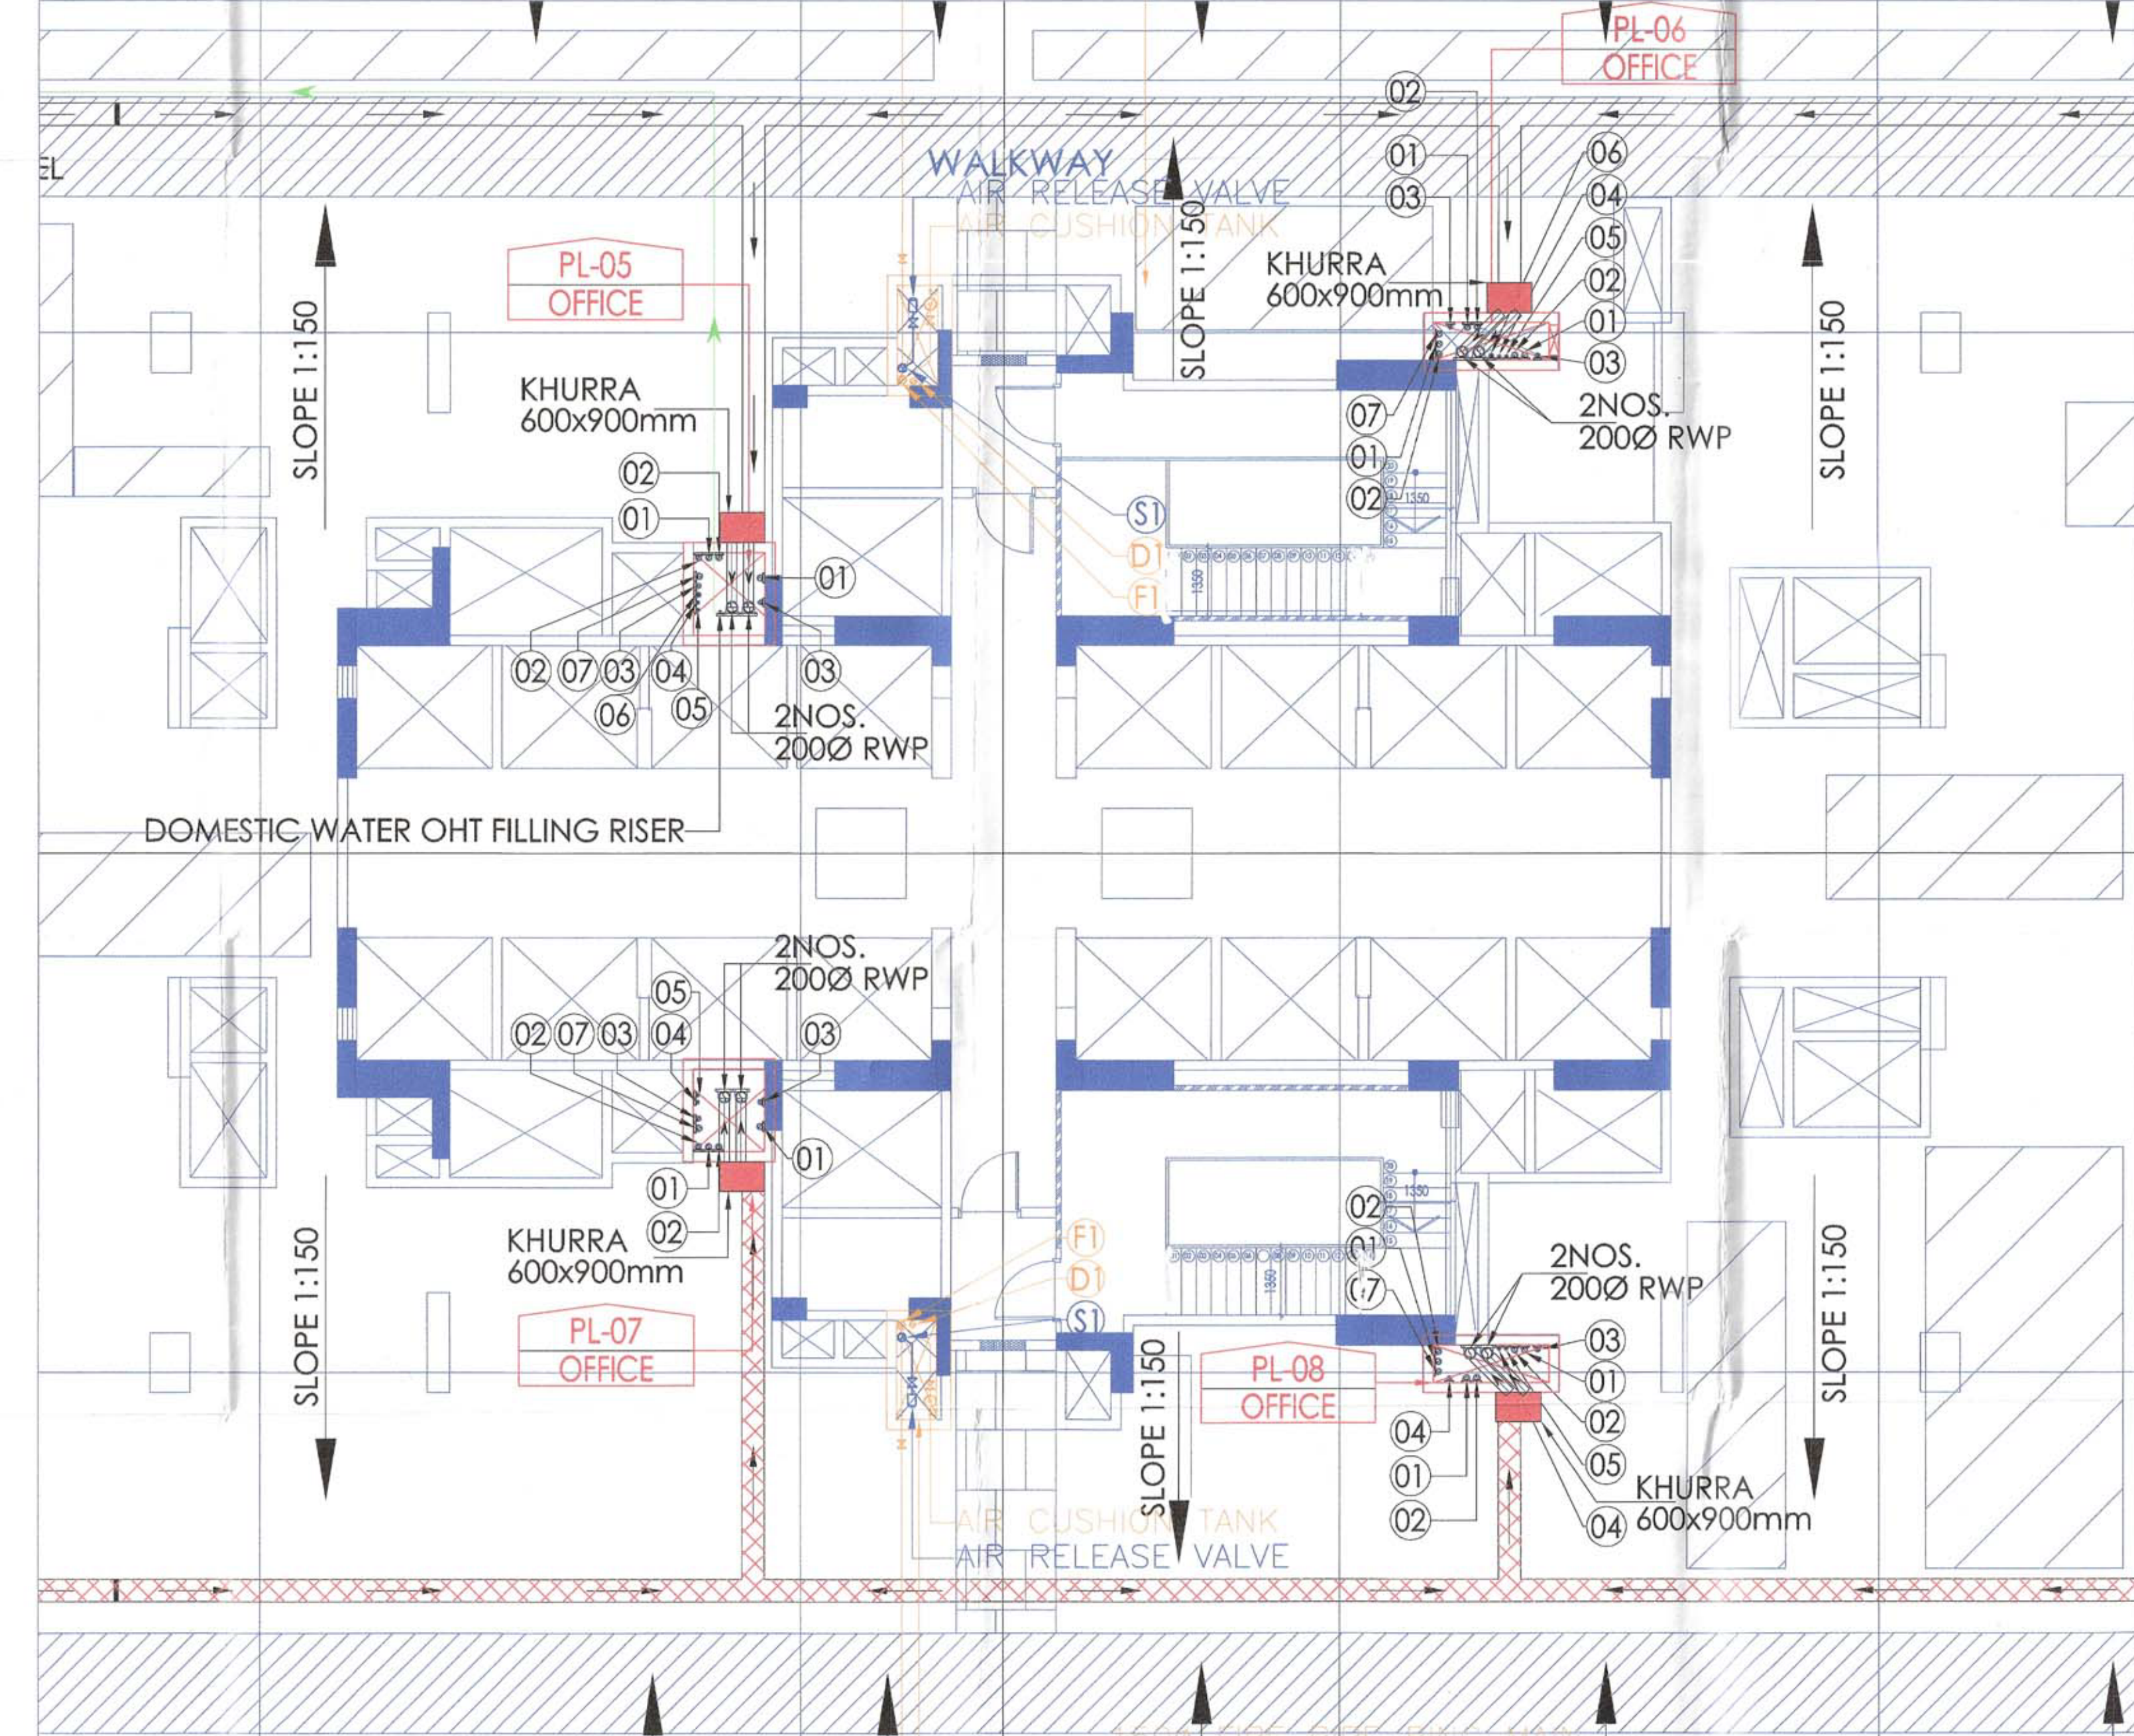

ENLARGEMENT DETAIL OF TYPICAL CORE (SCALE 1:100)

Checked and Signed off for Public Health (Internal) Service only subject to comments by the concerned authority.
 18/08/2017
 Supervising Engineer (PHE)
 PHE/RA, Punjab.